



West Bank Barrel Building  
Site Lighting Plan

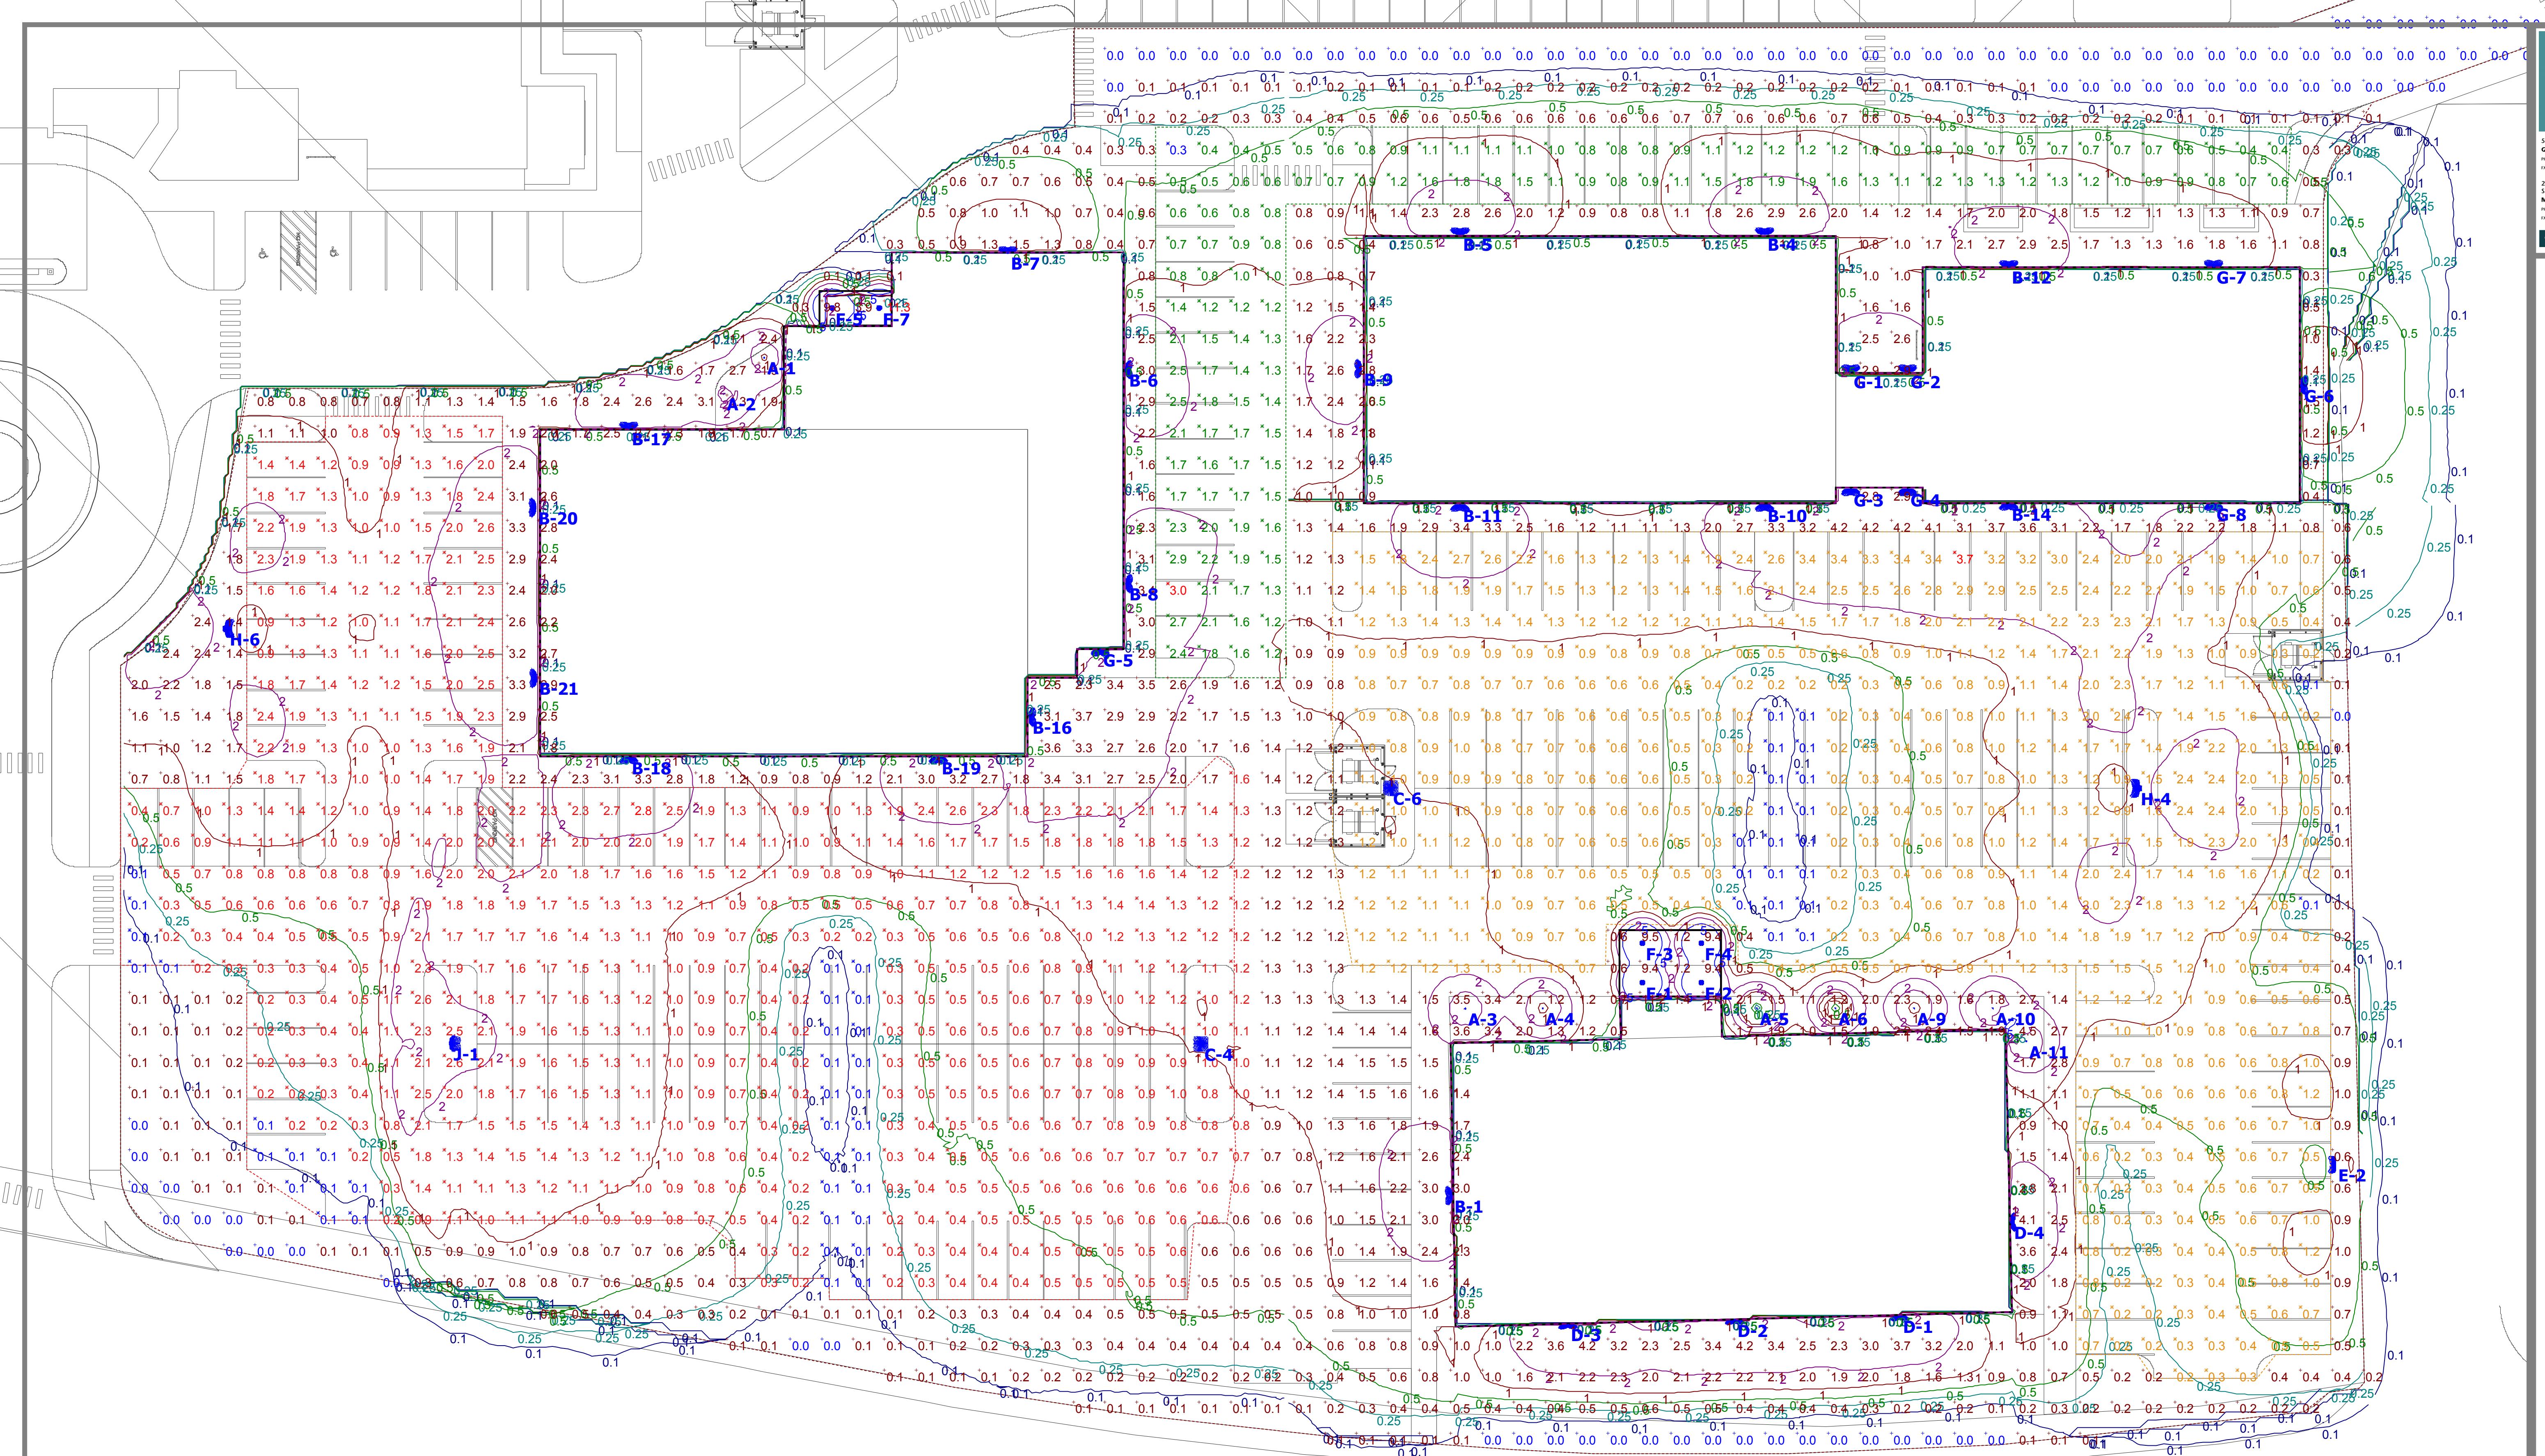

Plan View  
Scale - 1" = 20ft

Designer  
S. Pickering  
Date  
9/7/2016  
Scale  
Not to Scale  
Drawing No.  
Summary

West Bank Barrel Building  
Site Lighting Plan

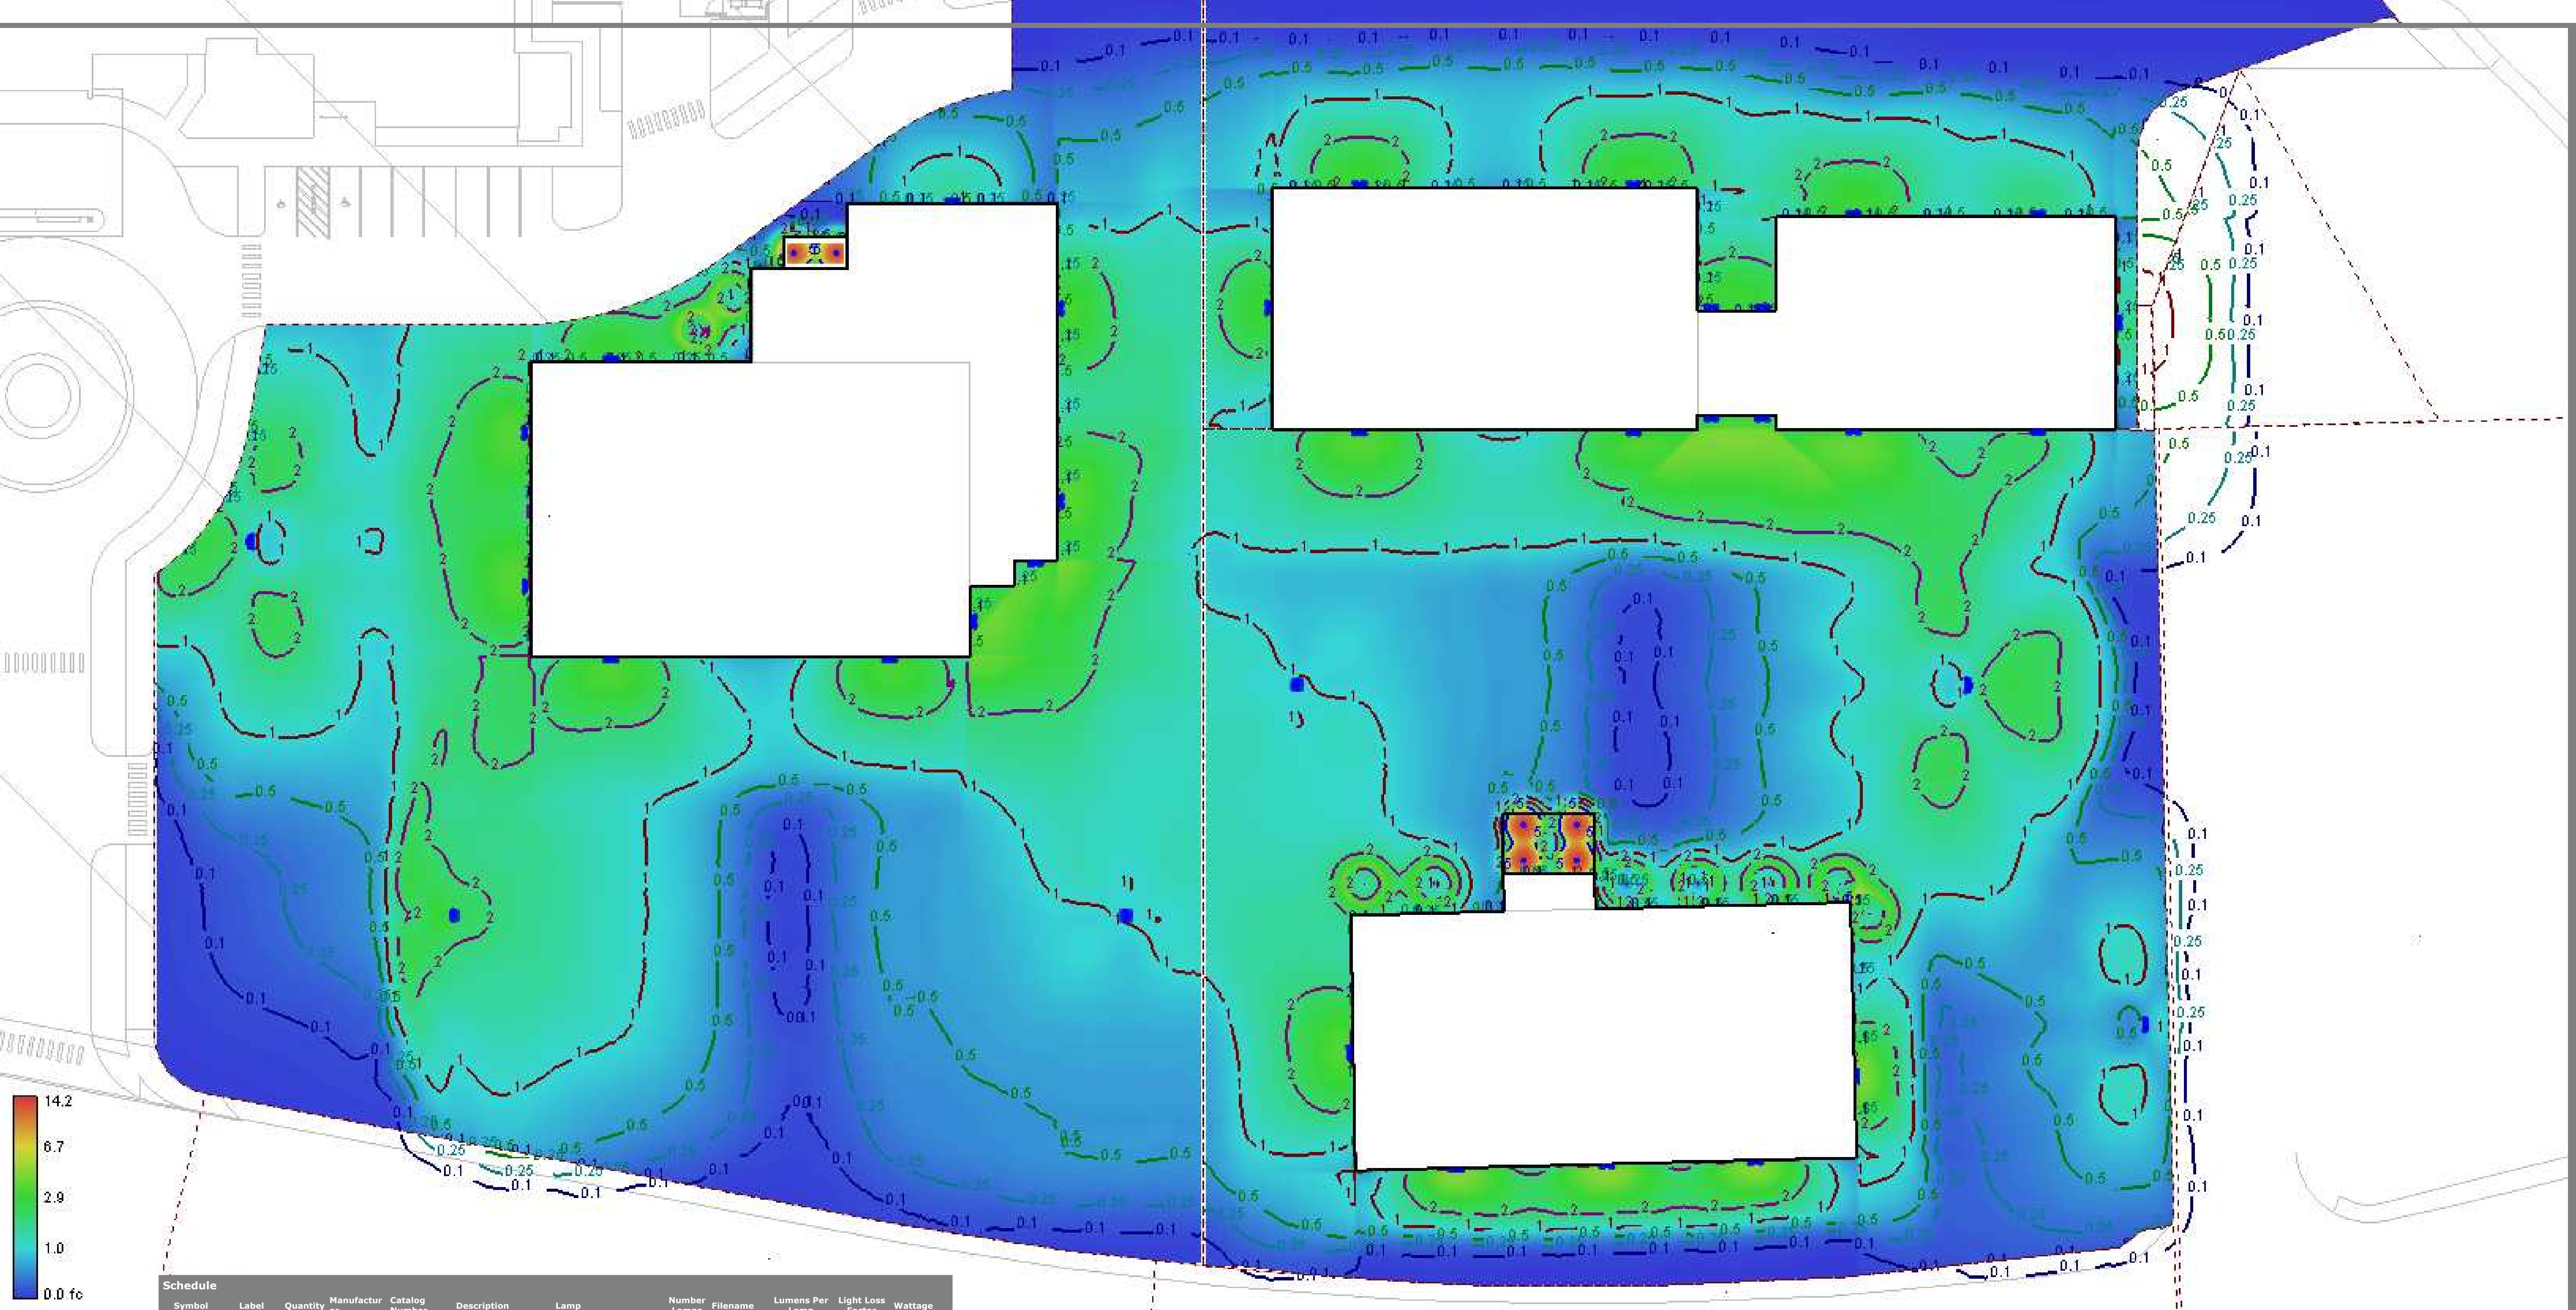

Schedule								
Symbol	Label	Quantity	Manufacturer	Catalog Number	Description	Lamp	Number Lamps	Filename
(○)	A	9	PHILIPS GARDCO	BRM830-CW-360-BRP	LED BOLLARD	(30)1W WHITE LEDS RATED FOR 80 LUMENS	1	BRM830-CW-360-BRP.ies
(○)	B	17	PHILIPS GARDCO	106L-16L-1000-NW-G1-3	PHILIPS 100 LINE LED SCONCE	(1) LEDGINE 3.1 LIGHT ARRAYS OF 16 LEDs (LUXEON T) AT 55W	1	106L-16L-1000-NW-G1-3.ies
(○)	C	2	PHILIPS GARDCO	ECF-5-135LA-6470-NW	ECOFORM	SLE 2.1 LIGHT ARRAY OF 64 LUXEON T LEDs DRIVEN AT 700mA	1	ECF-5-135LA-6470-NW.ies
(○)	D	4	PHILIPS GARDCO	106L-16L-530-NW-G1-2	PHILIPS 100 LINE LED SCONCE	(1) LEDGINE 3.1 LIGHT ARRAYS OF 16 LEDs (LUXEON T) AT 28W	1	106L-16L-530-NW-G1-2.ies
(○)	E	1	PHILIPS GARDCO	ECF-3-55LA-3253-NW-1S	ECOFORM	SLE 2.1 LIGHT ARRAY OF 32 LUXEON T LEDs DRIVEN AT 530mA	1	ECF-3-55LA-3253-NW-1S.ies
(○)	F	6	PHILIPS LIGHTOLIER	C6L10DL35KM CLWVB-C6L10NUVBZ10V	PHILIPS Calulite White LED 6 Inch Round Aperture	LED, LUMINAIRE OUTPUT = 1040 LMS	1	C6L10NUVBZ10V-C6L10DL35K MCLWB.IES
(○)	G	8	PHILIPS GARDCO	121-16L-530-NW-G3-3		(1) LEDGINE 3.1 LIGHT ARRAYS OF 16 LEDs (LUXEON T) AT 28W	1	121-16L-530-NW-G3-3.IES
(○)	H	2	PHILIPS GARDCO	ECF-3-135LA-6470-NW	ECOFORM	SLE 2.1 LIGHT ARRAY OF 64 LUXEON T LEDs DRIVEN AT 700mA	1	ECF-3-135LA-6470-NW.ies
(○)	J	1	PHILIPS GARDCO	ECF-4-135LA-6470-NW	ECOFORM	SLE 2.1 LIGHT ARRAY OF 64 LUXEON T LEDs DRIVEN AT 700mA	1	ECF-4-135LA-6470-NW.ies

Statistics					
Description	Symbol	Avg	Max	Min	Max/Min Avg/Avg
Calc Zone #10	+	1.1 fc	11.3 fc	0.0 fc	N/A/N/A
Calc Zone #10	+	0.2 fc	1.4 fc	0.0 fc	N/A/N/A
Calc Zone #11	+	1.0 fc	1.7 fc	0.4 fc	4.3:1/2.5:1
East Parking Lots	X	1.2 fc	3.0 fc	0.3 fc	10.0:1/4.0:1
Northern Parking Lots	X	1.0 fc	2.8 fc	0.1 fc	28.0:1/10.0:1
Southern Parking Lots	X	1.0 fc	3.7 fc	0.1 fc	37.0:1/10.0:1